


Drawing name: J:\DAM\Project Files\24-0-19 - JM - New Daycare for BOS Keystone Bldg\Floor Plans.dwg Jun 18, 2024 - 9:48am

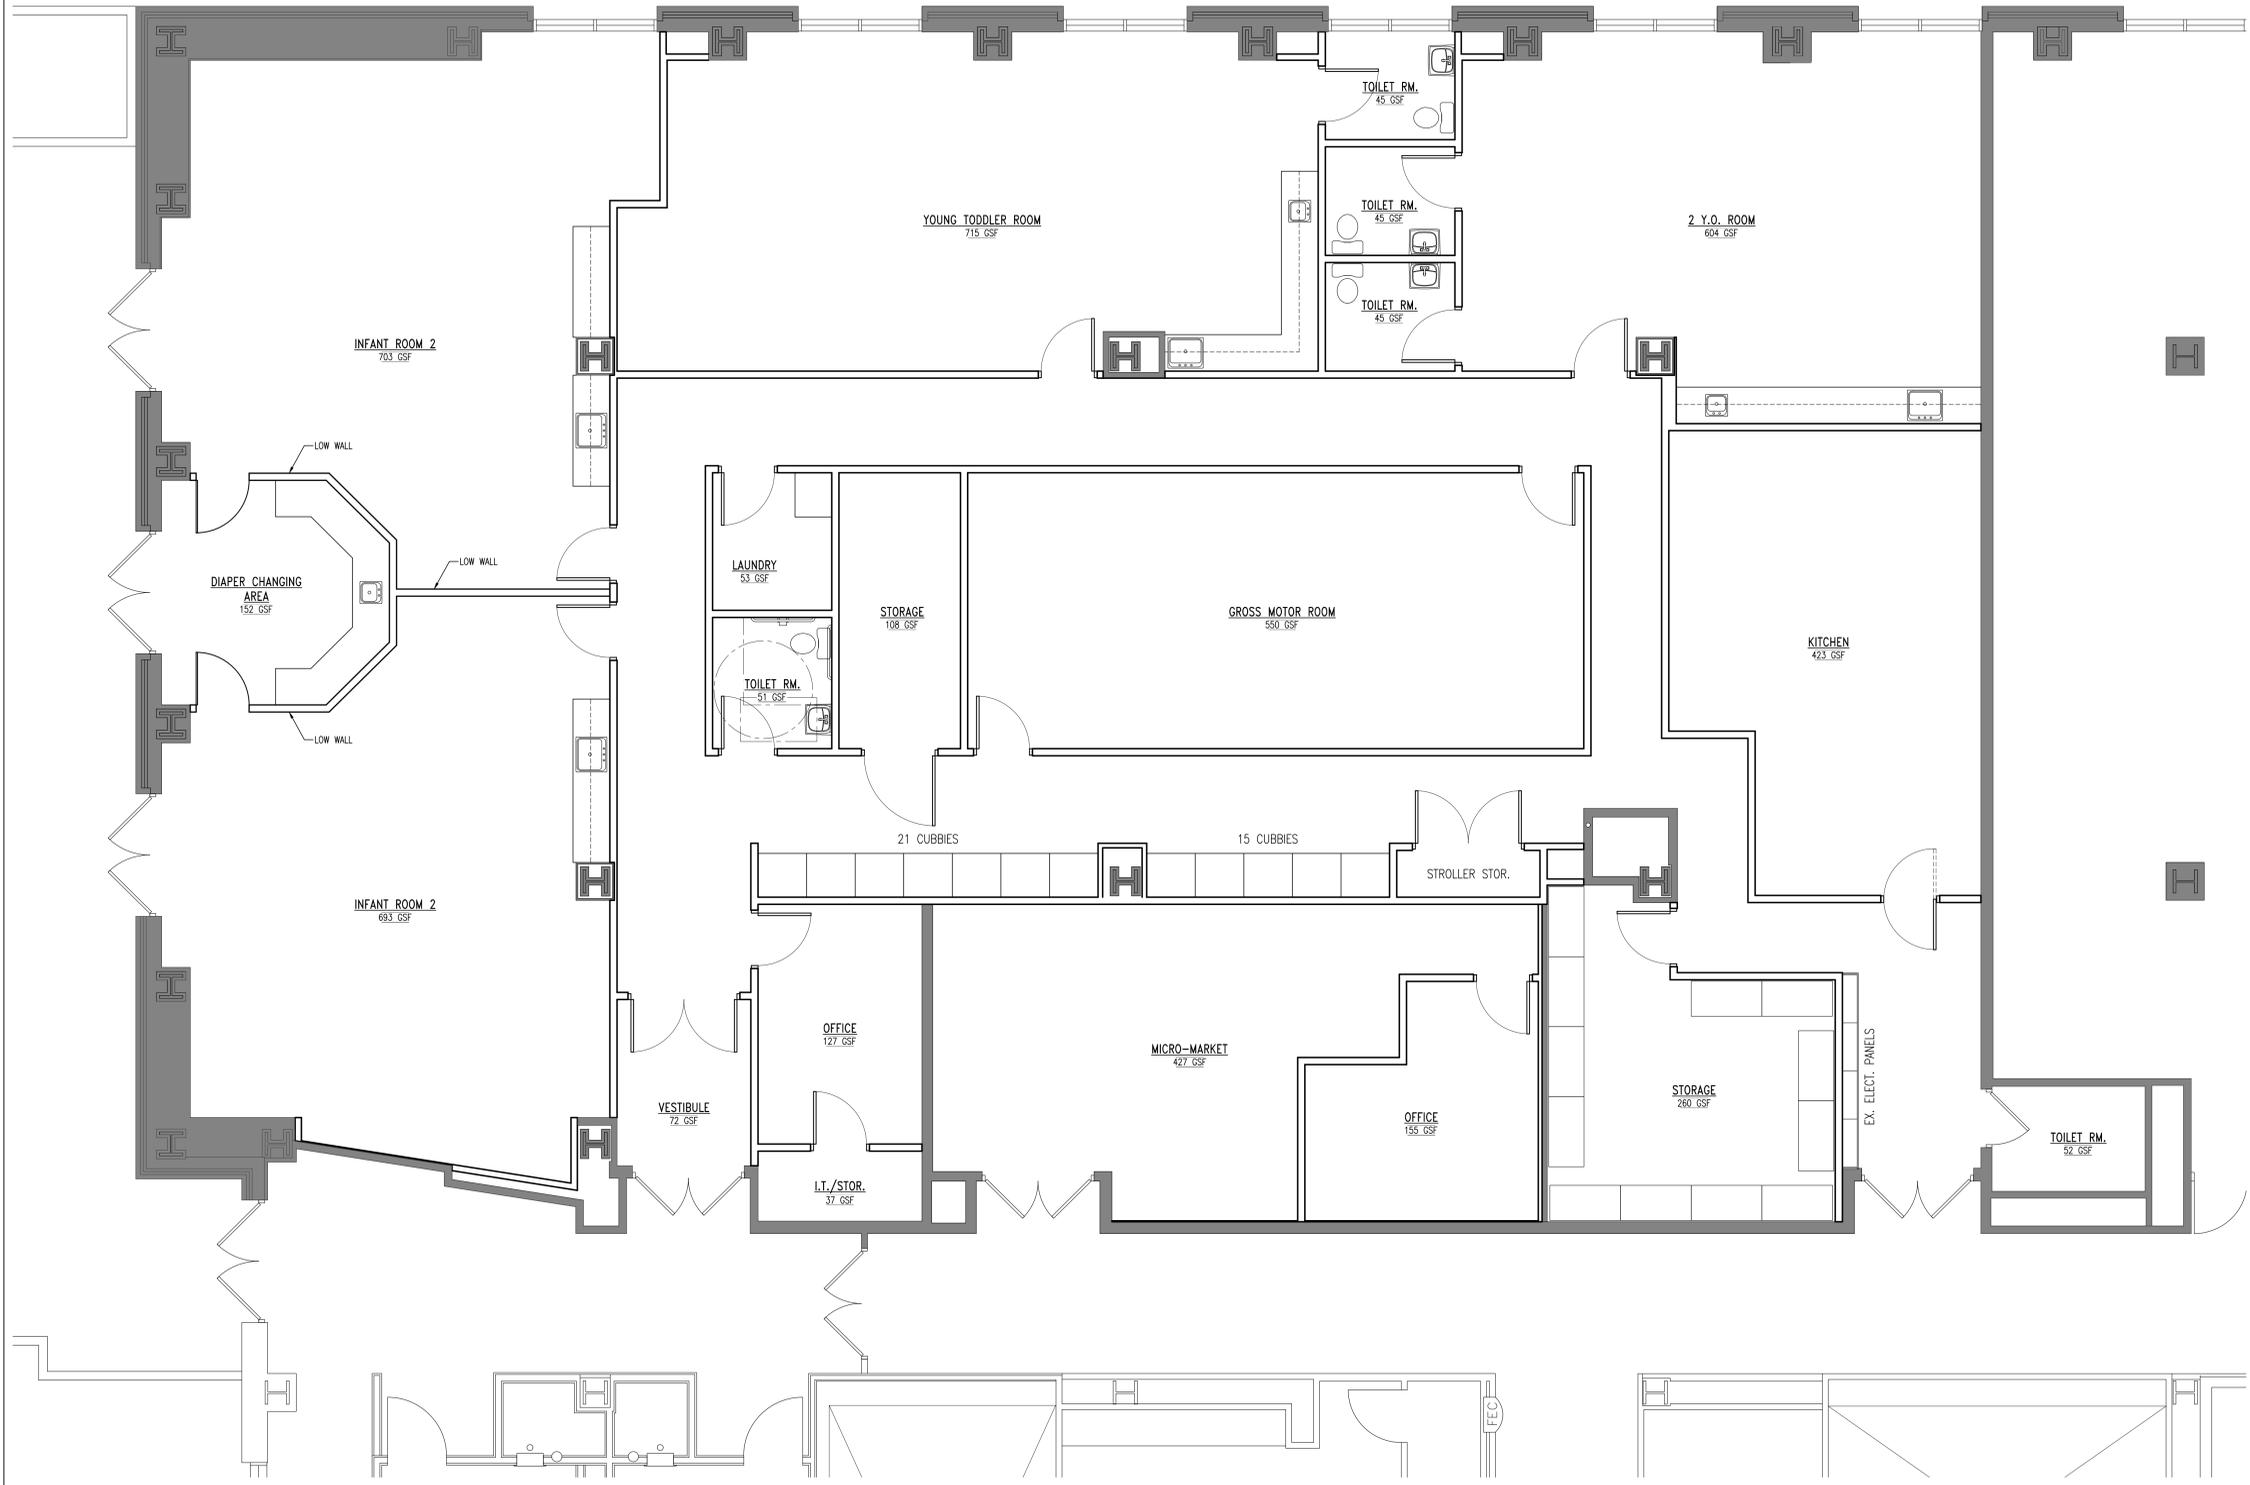

1 FLOOR PLAN
A-101 SCALE: 1/4" = 1'-0"

DILLOW ASSOCIATES
architects
1750 CLOVERTON DRIVE
COLUMBIA, PA 17512
717.684.0010
INFO@DILLOWASSOCIATES.COM



SEAL:

NEW DAYCARE CENTER FOR
KEYSTONE EARLY LEARNING CENTER
COMMONWEALTH KEYSTONE BUILDING
400 NORTH STREET
HARRISBURG DAUPHIN COUNTY, PA 17120

DATE: 06.14.2024
ITEM: DD PLAN FOR REVIEW

PROJECT NUMBER: 24-0-19
DRAWN BY: SBD
FLOOR PLAN