

Annette M. Cevis
Right of Way Agent
PPL Electric Utilities
100 Commerce Drive
Mechanicsburg, PA 17050-2675
Tel. 717.691.2920 Fax 717.691.2999
amcevis@pplweb.com



February 27, 2019

Ms. Rosemary Chiavetta, Secretary
Pennsylvania Public Utility Commission
P.O. Box 3265
Harrisburg, PA 17105-3265

RE: PUC DOCKET # A-2018-3005704
REVISED PLAN – DWG EU00536481

Dear Secretary, Chiavetta:

Enclosed you will find a copy of the revised plan [PPL DWG EU00536481]. A revision was necessary to address Norfolk Southern's 12-kV electric power circuit clearance requirement. The plan was revised to have a 34-foot measured sag from the bottom to the top of rail.



A copy of this plan was submitted to the PUC.

Should you have any questions please contact this office.

Sincerely,

Annette M Cevis

Annette M. Cevis
Right of Way Agent

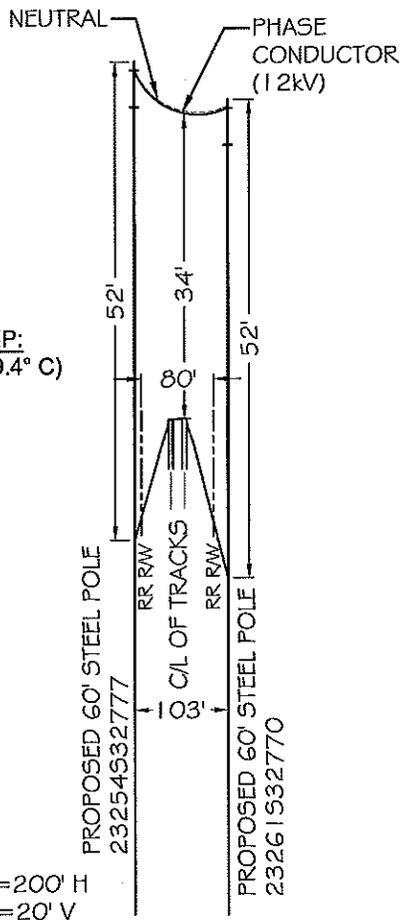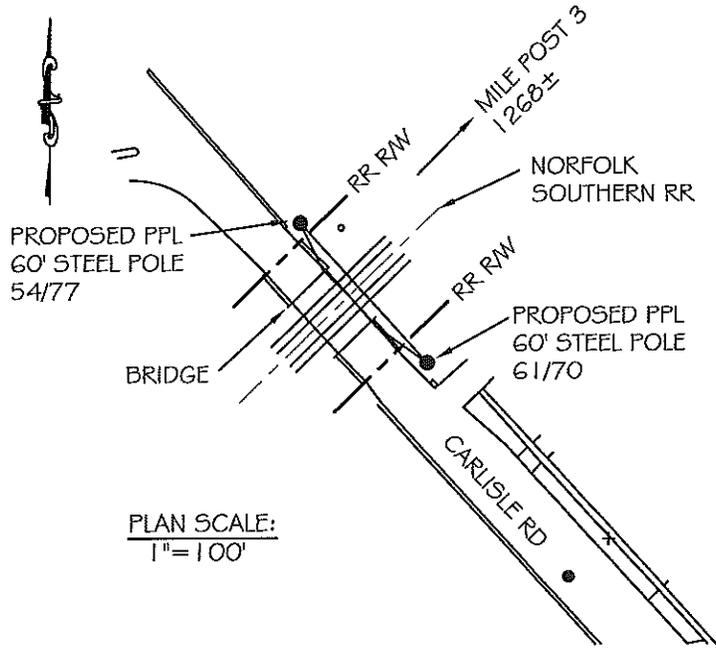

PROFILE
SCALE: 1"=200' H
1"=20' V



REVISION
BY
REV'D
APPR.
ECN/FCN
DATE
ACCT.

ACCT.- 288531
ECN #- 10148
SCALE- AS SHOWN
BY- JJA
REV'D- KAB

12kV CROSSING OVER	
NORFOLK SOUTHERN RAILROAD COMPANY TRACKS (CROSSING 592203M)	
APPROX. 1268FT NE OF MILEPOST 3	
LOWER ALLEN TWP.	CUMBERLAND CO., PA
APPROVAL K.A. Bowerman	DATE 1/2019
PPL ELECTRIC UTILITIES	
AC	A
CAD ID	FORMAT
DRAWING NO. EU00536481	
SHEET NO. 1	REVISION 1

PLAN AND PROFILE
N SHARE
C SORTS
LOC CODE
LOC CODE
LOC CODE
CU56 PRIMARY LOC CODE