





BY REV'D APPR

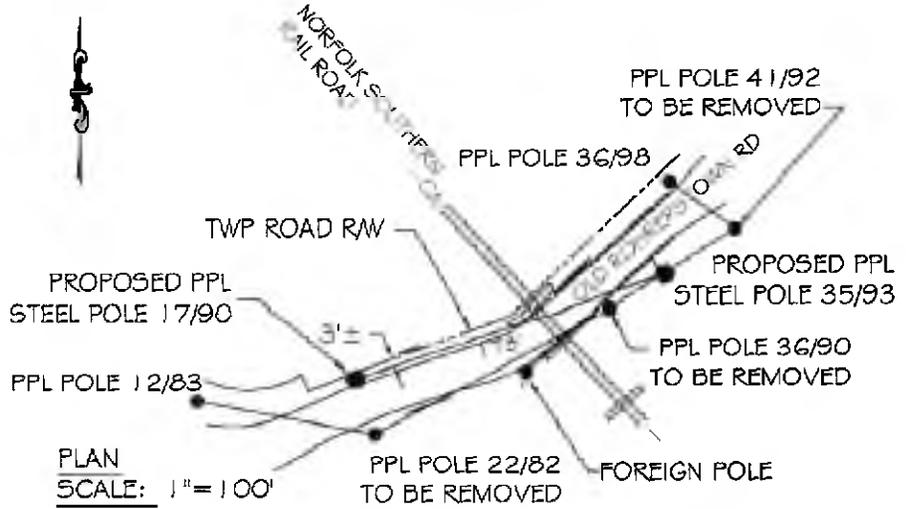

PLAN AND PROFILE

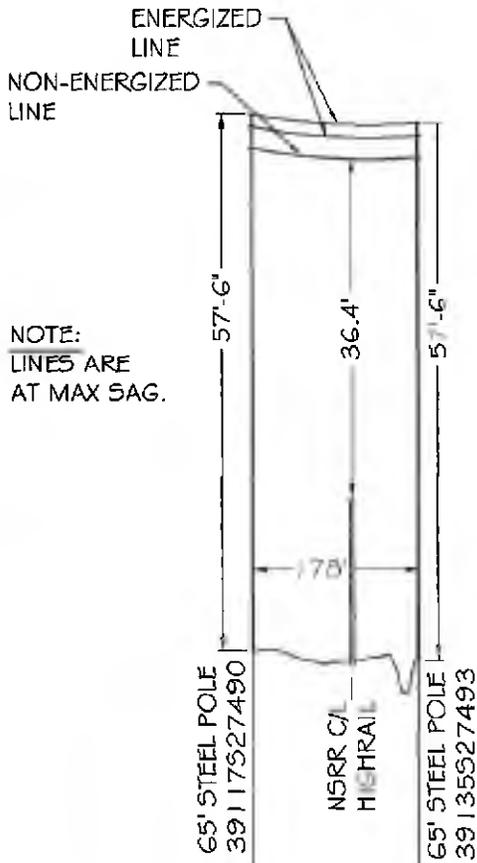

NOTE:
LINES ARE
AT MAX SAG.

PROFILE
SCALE: 1"=200' H
1"=20' V

A-2020-3023280

CERTIFIED CORRECT PLANS

[Signature]
Professional Engineer
Approved by Bureau of Technical Utility Services

PA PUBLIC UTILITY COMMISSION

ATTEST *[Signature]*
Secretary

N SHARE

C SORTS

LOC CODE

LOC CODE

LC73 LOC CODE

LC64 PRIMARY LOC CODE



ACCT.	ACCT.- 252395
ECN/FCN	ECN #- 13679
DATE	SCALE- AS SHOWN
NO	BY- JJA
	REV'D- VJG
	APPROVAL Vito J Galle
	DATE 9/2020
	AC A
	CAD ID/FORMAT

PPL CROSSING (12kv)	
PPL CROSSING OVER NORFOLK SOUTHERN RR	
AT MILEPOST 0001.790	
E HEMPFIELD & MANHEIM TWP. LANCASTER CO., PA	
PPL ELECTRIC UTILITIES	
DRAWING NO.	SHEET NO. REVISION
EU00556736	1 0