
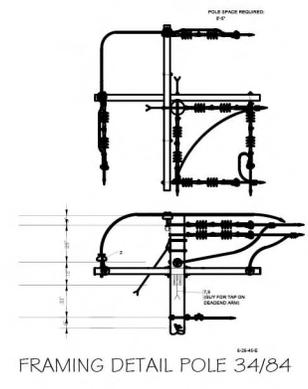
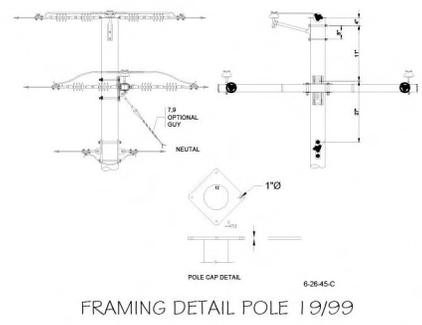
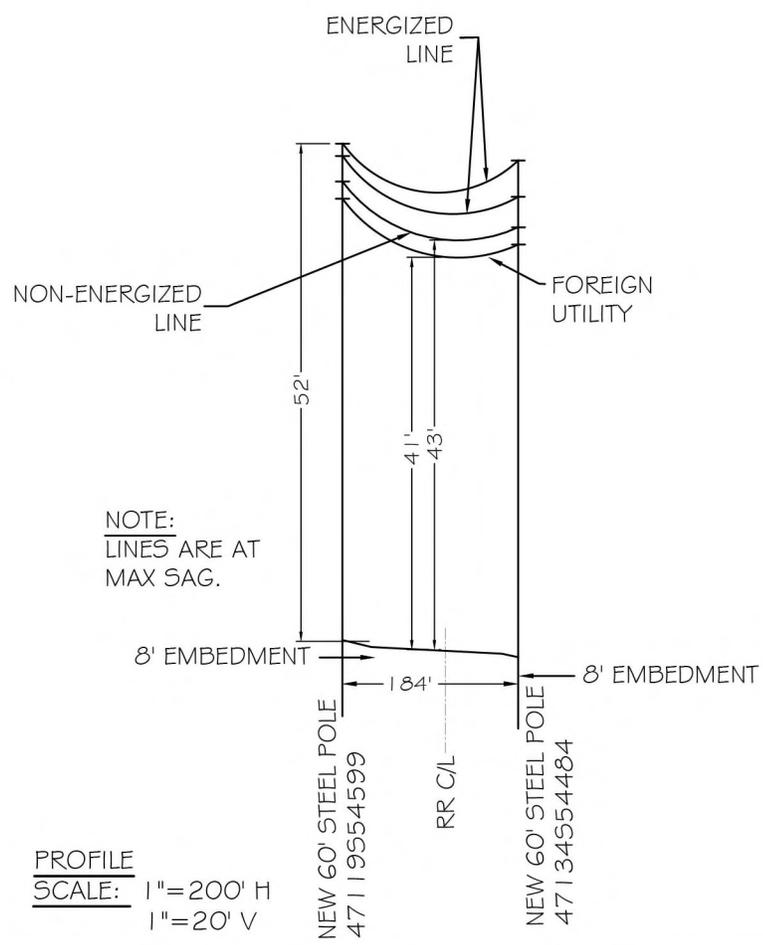


**CERTIFIED CORRECT PLANS**

*Will M. D. P.E.*  
 Professional Engineer  
 Approved by Bureau of Technical Utility Services

**PA PUBLIC UTILITY COMMISSION**

ATTEST *Matthew L. Hensler* **10/9/2025**  
 Secretary **Docket: A-2025-3055936**

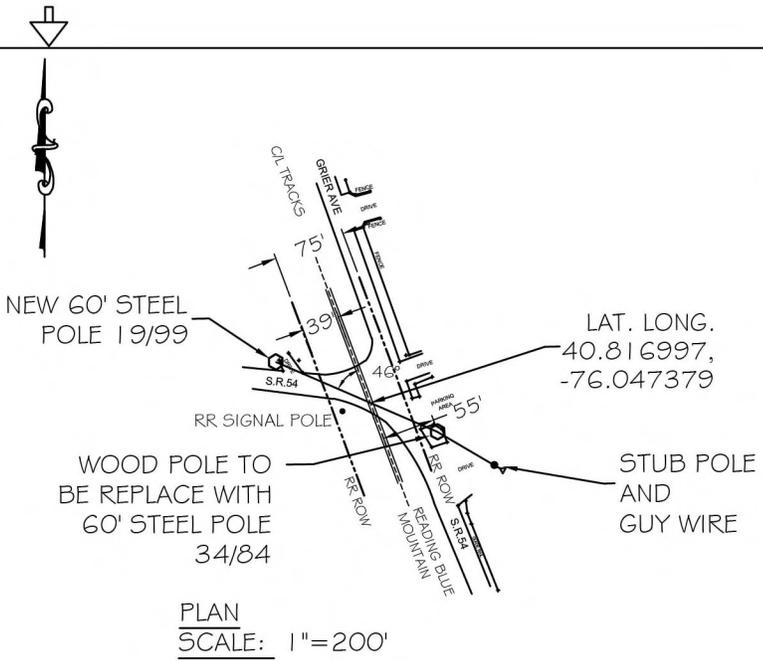

PROFILE  
 SCALE: 1"=200' H  
 1"=20' V



REVISION  
 ECN/FCN  
 DATE  
 ACCT.  
 NO.

PLAN AND PROFILE  
 SHARE  
 SORTS  
 LOC CODE  
 LOC CODE  
 LOC CODE  
 PRIMARY LOC CODE

ACCT.- 13802221 ECN #- 19543 SCALE- AS SHOWN BY- JJA REV'D- JAZ	<b>PPL CROSSING (12kv)</b> PPL CROSSING READING BLUE MOUNTAIN RAILROAD COMPANY AT LAT. 40.816997 LONG. -76.047379 BARNVILLE DR & GRIER AVE RYAN TWP. SCHUYLKILL CO., PA
APPROVAL M.J. Rebeck	DATE 06/2025
AC      A	<b>PPL ELECTRIC UTILITIES</b>
DRAWING NO.	SHEET NO.      REVISION
CAD ID      FORMAT	<b>EU00588439</b> <b>1      0</b>