


2026-3060070


**CERTIFIED CORRECT PLANS**

*Will M. D. P.E.*  
Professional Engineer  
Approved by Bureau of Technical Utility Services  
**PA PUBLIC UTILITY COMMISSION**


ATTEST *Matthew L. Hensch*  
Secretary

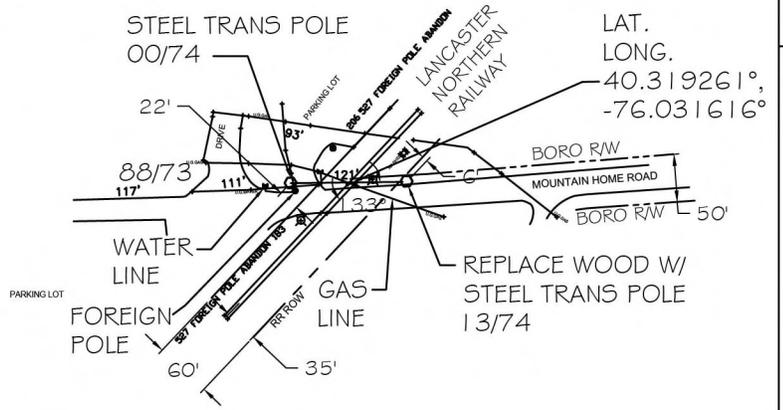

PLAN  
SCALE: 1" = 200'

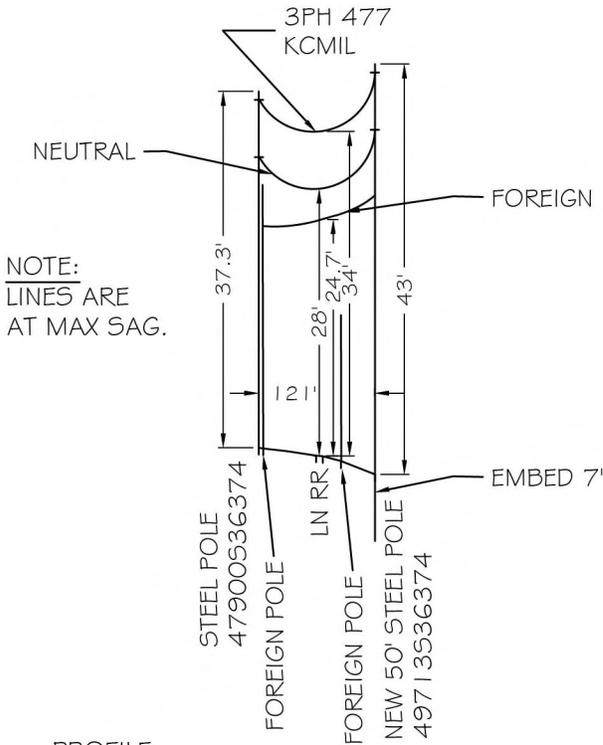

PROFILE  
SCALE: 1" = 200' H  
1" = 20' V

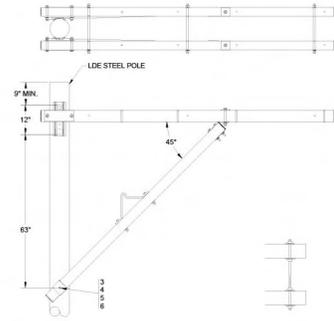

DOUBLE ALLEY ARM FOR LDE STEEL POLES



PPL ELECTRIC UTILITIES

NO. DATE REV'D- BMP BY- JJA ACCT.- 13097047 ECN #- 20218 SCALE- AS SHOWN

SINKING SPRING BORO. APPROVAL J.C. Portz DATE 11/2025

**PPL CROSSING (12kv)**

PPL STORM HARDING CROSSING OVER LANCASTER NORTHERN RR  
MTN. HOME RD AT LAT. 40.319261°, LONG. -76.031616°

**PPL ELECTRIC UTILITIES**

AC A CAD ID FORMAT

DRAWING NO.

**EU00595091**

SHEET NO.

REVISION  
**1 0**

PLAN AND PROFILE  
N SHARE  
C SORTS  
LOC CODE  
LOC CODE  
LOC CODE  
BE24 PRIMARY LOC CODE